


Luminaire Schedule					
Symbol	Qty	Label	Description	LLF	Lum. Lumens
SA2	4	SA2	XTRA LTG#: VNTLEDL-03-231-4S-N-UIN-4-20-HSS / MTD AT 20' AFG	0.900	22073
SB	4	SB	CREE LTG#: XSPW-B-WM-3ME-2L-40K-UL-WH / WALL MTD AT 9' AFF	0.900	2483

Calculation Summary							
Label	CalcType	Units	Avg	Max	Min	Avg/Min	Max/Min
PARKING AREAS	Illuminance	Fc	3.83	7.8	1.1	3.48	7.09
PROPERTY LINE AT 5' AFG	Illuminance	Fc	1.51	17.9	0.0	N.A.	N.A.

1 AERIAL SKETCH

2 LIGHTING DATA

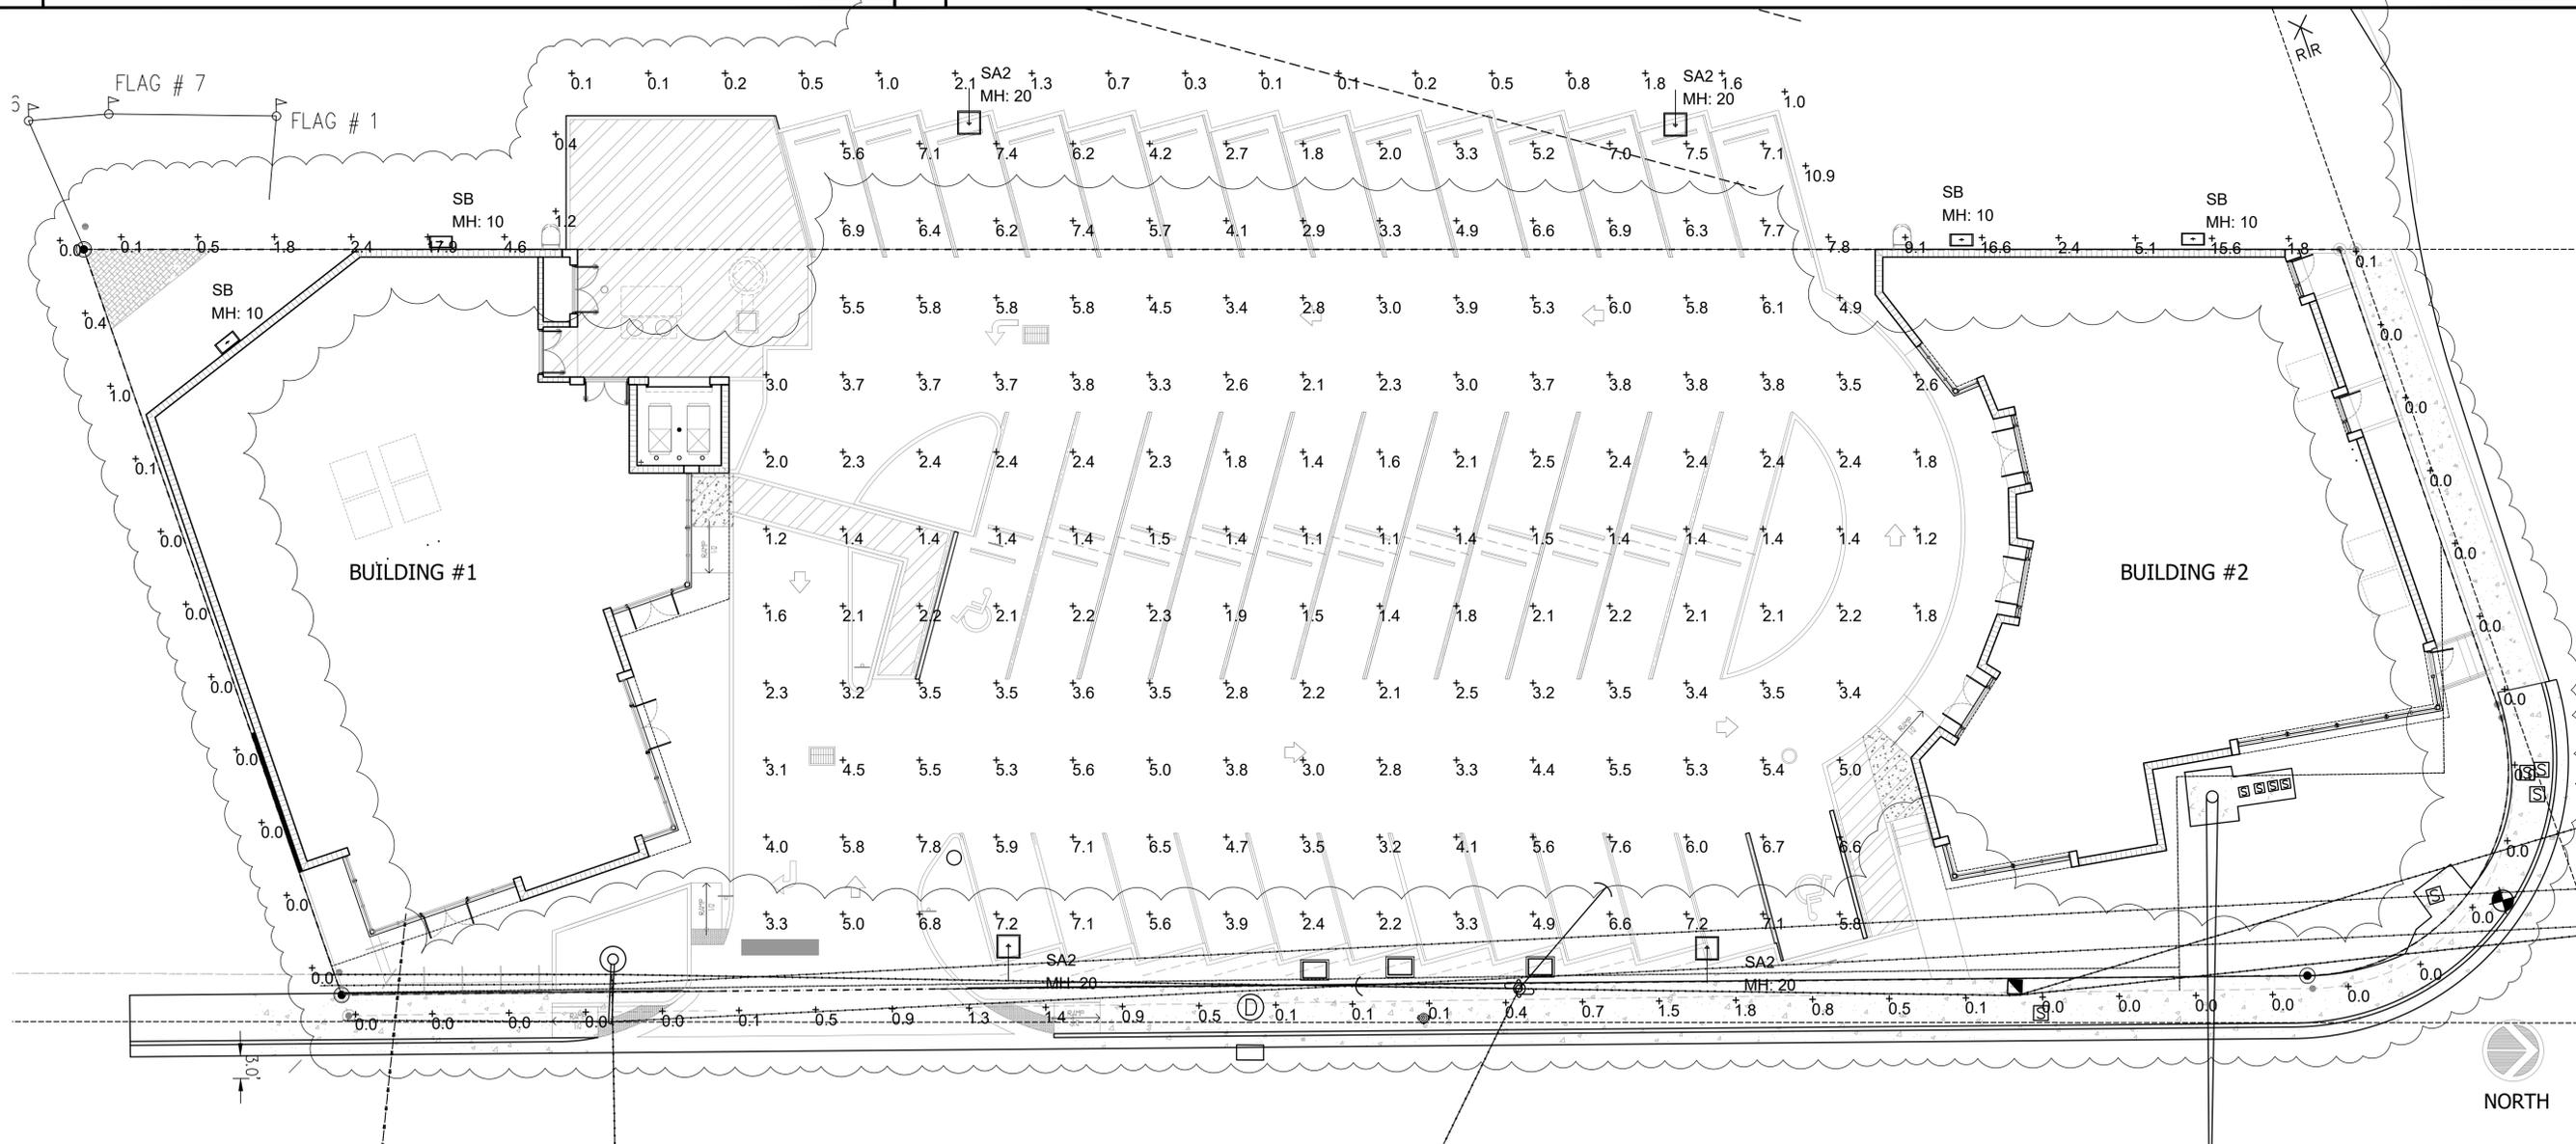

3 PHOTOMETRIC SITE PLAN  
SCALE: 3/32" = 1'-0"

**KallerArchitecture**  
 AA# 26001212  
 2417 Hollywood Blvd.  
 Hollywood Florida 33020  
 954.920.5746  
 joseph@kallerarchitects.com  
 www.kallerarchitects.com

SEAL  
 STATE OF FLORIDA  
 JOSEPH B. KALLER  
 R.A.  
 0009239  
 REGISTERED ARCHITECT  
 JOSEPH B. KALLER  
 FLORIDA R.A. # 0009239

PROJECT TITLE  
 "17200 SHOPES"  
 17150 BISCAYNE BLVD  
 NORTH MIAMI BEACH, FL 33160

SHEET TITLE  
 PHOTOMETRIC PLAN

REVISIONS		
No.	DATE	DESCRIPTION
1	04/14/21	BD COMMENT/OWNER

This drawing, as an instrument of service, is and shall remain the property of the Architect and shall not be reproduced, published or used in any way without the permission of the Architect.

PROJECT No.: 17130  
 DATE: 04.07.20  
 DRAWN BY: GMV  
 CHECKED BY: JBK

SHEET  
**PH-1**

KALLER ARCHITECTURE, ALL RIGHTS RESERVED © 2018